
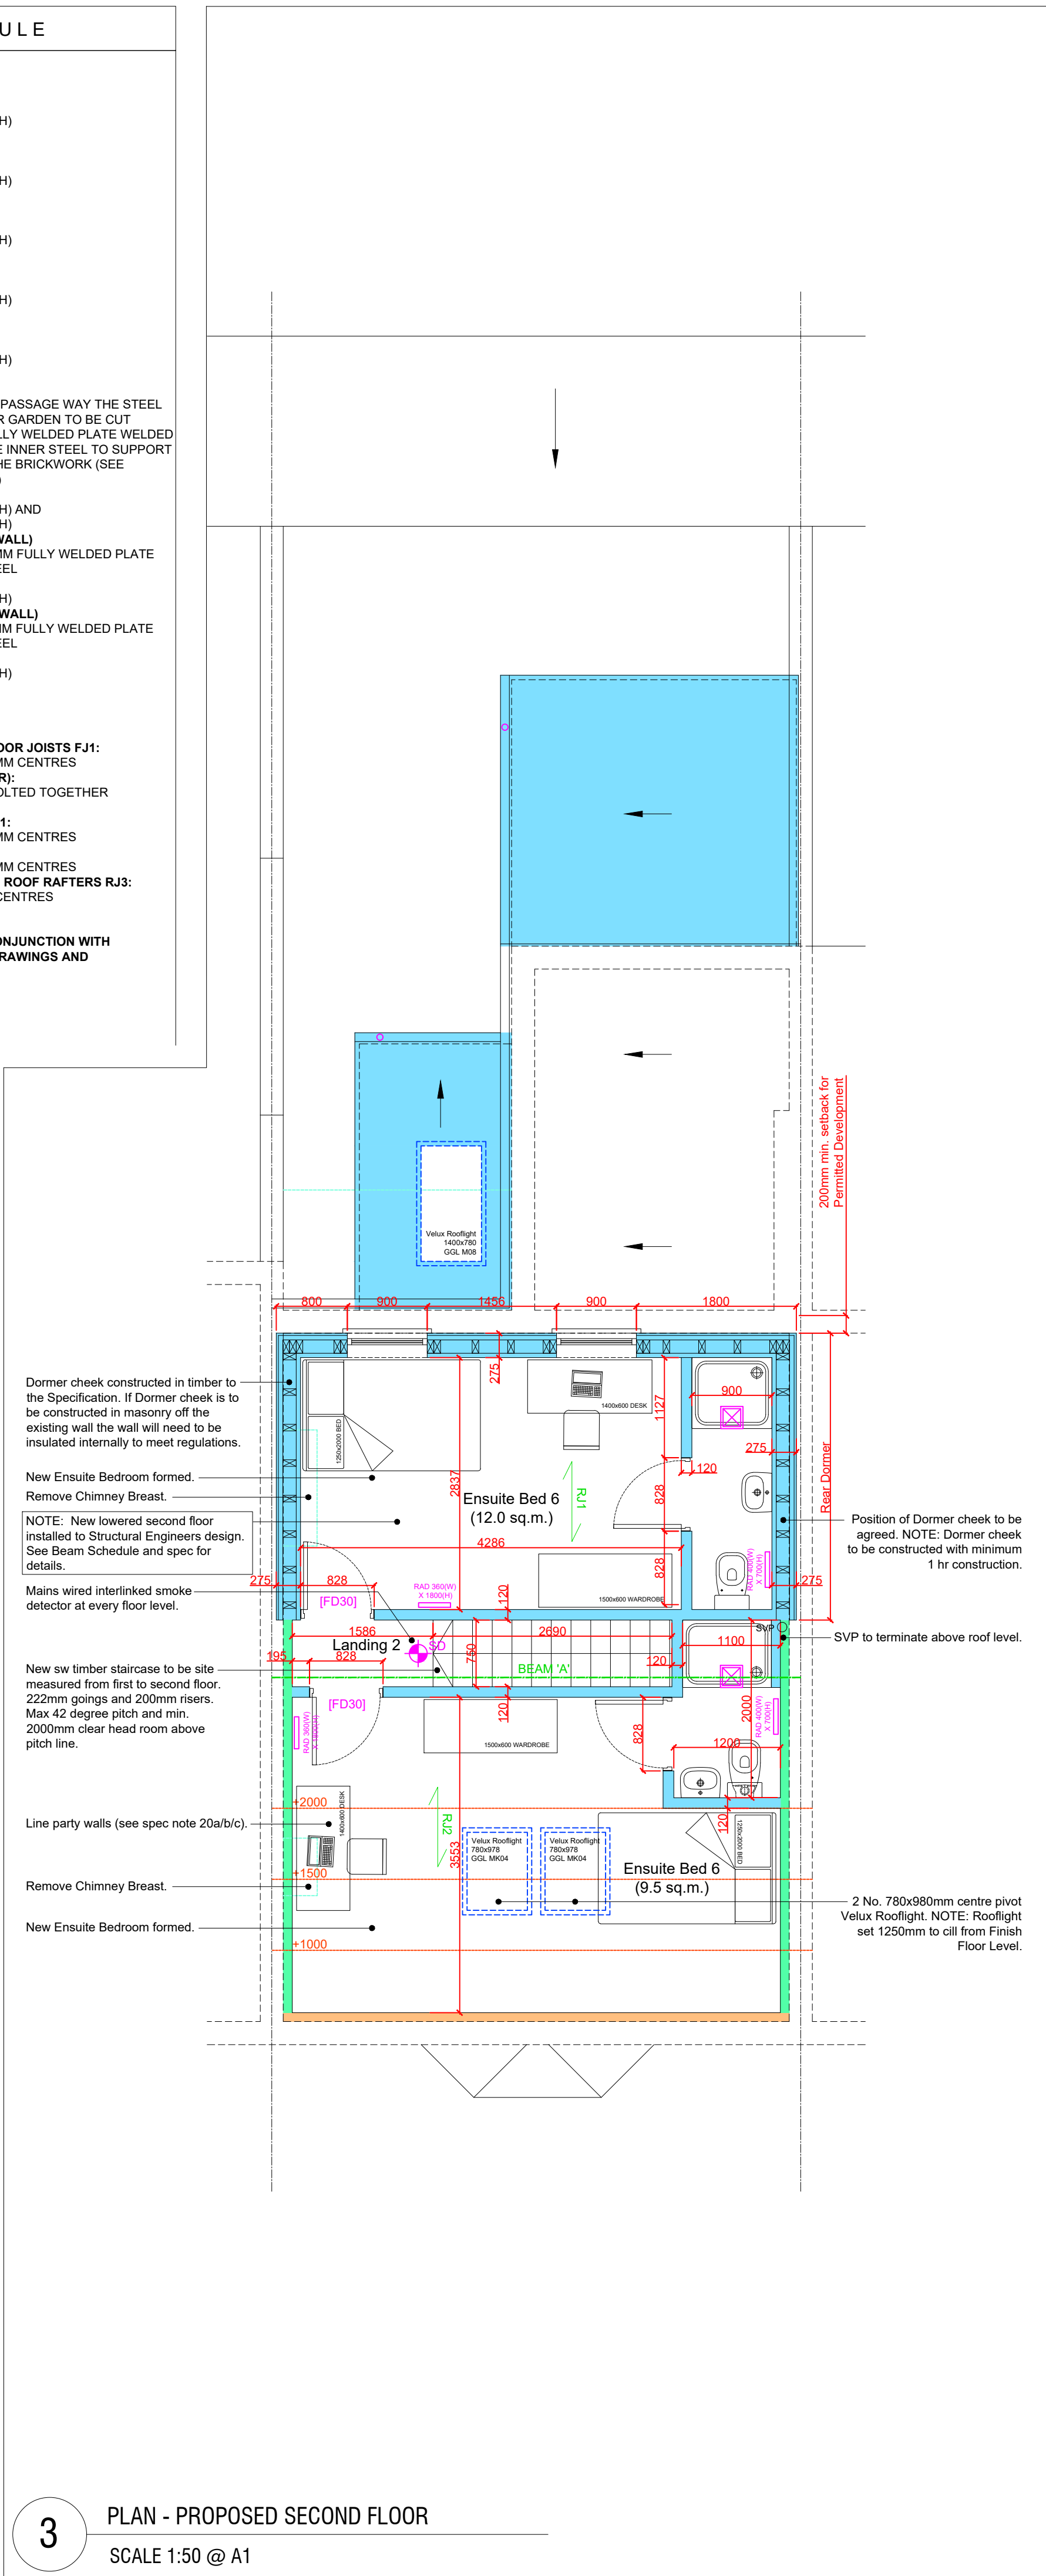
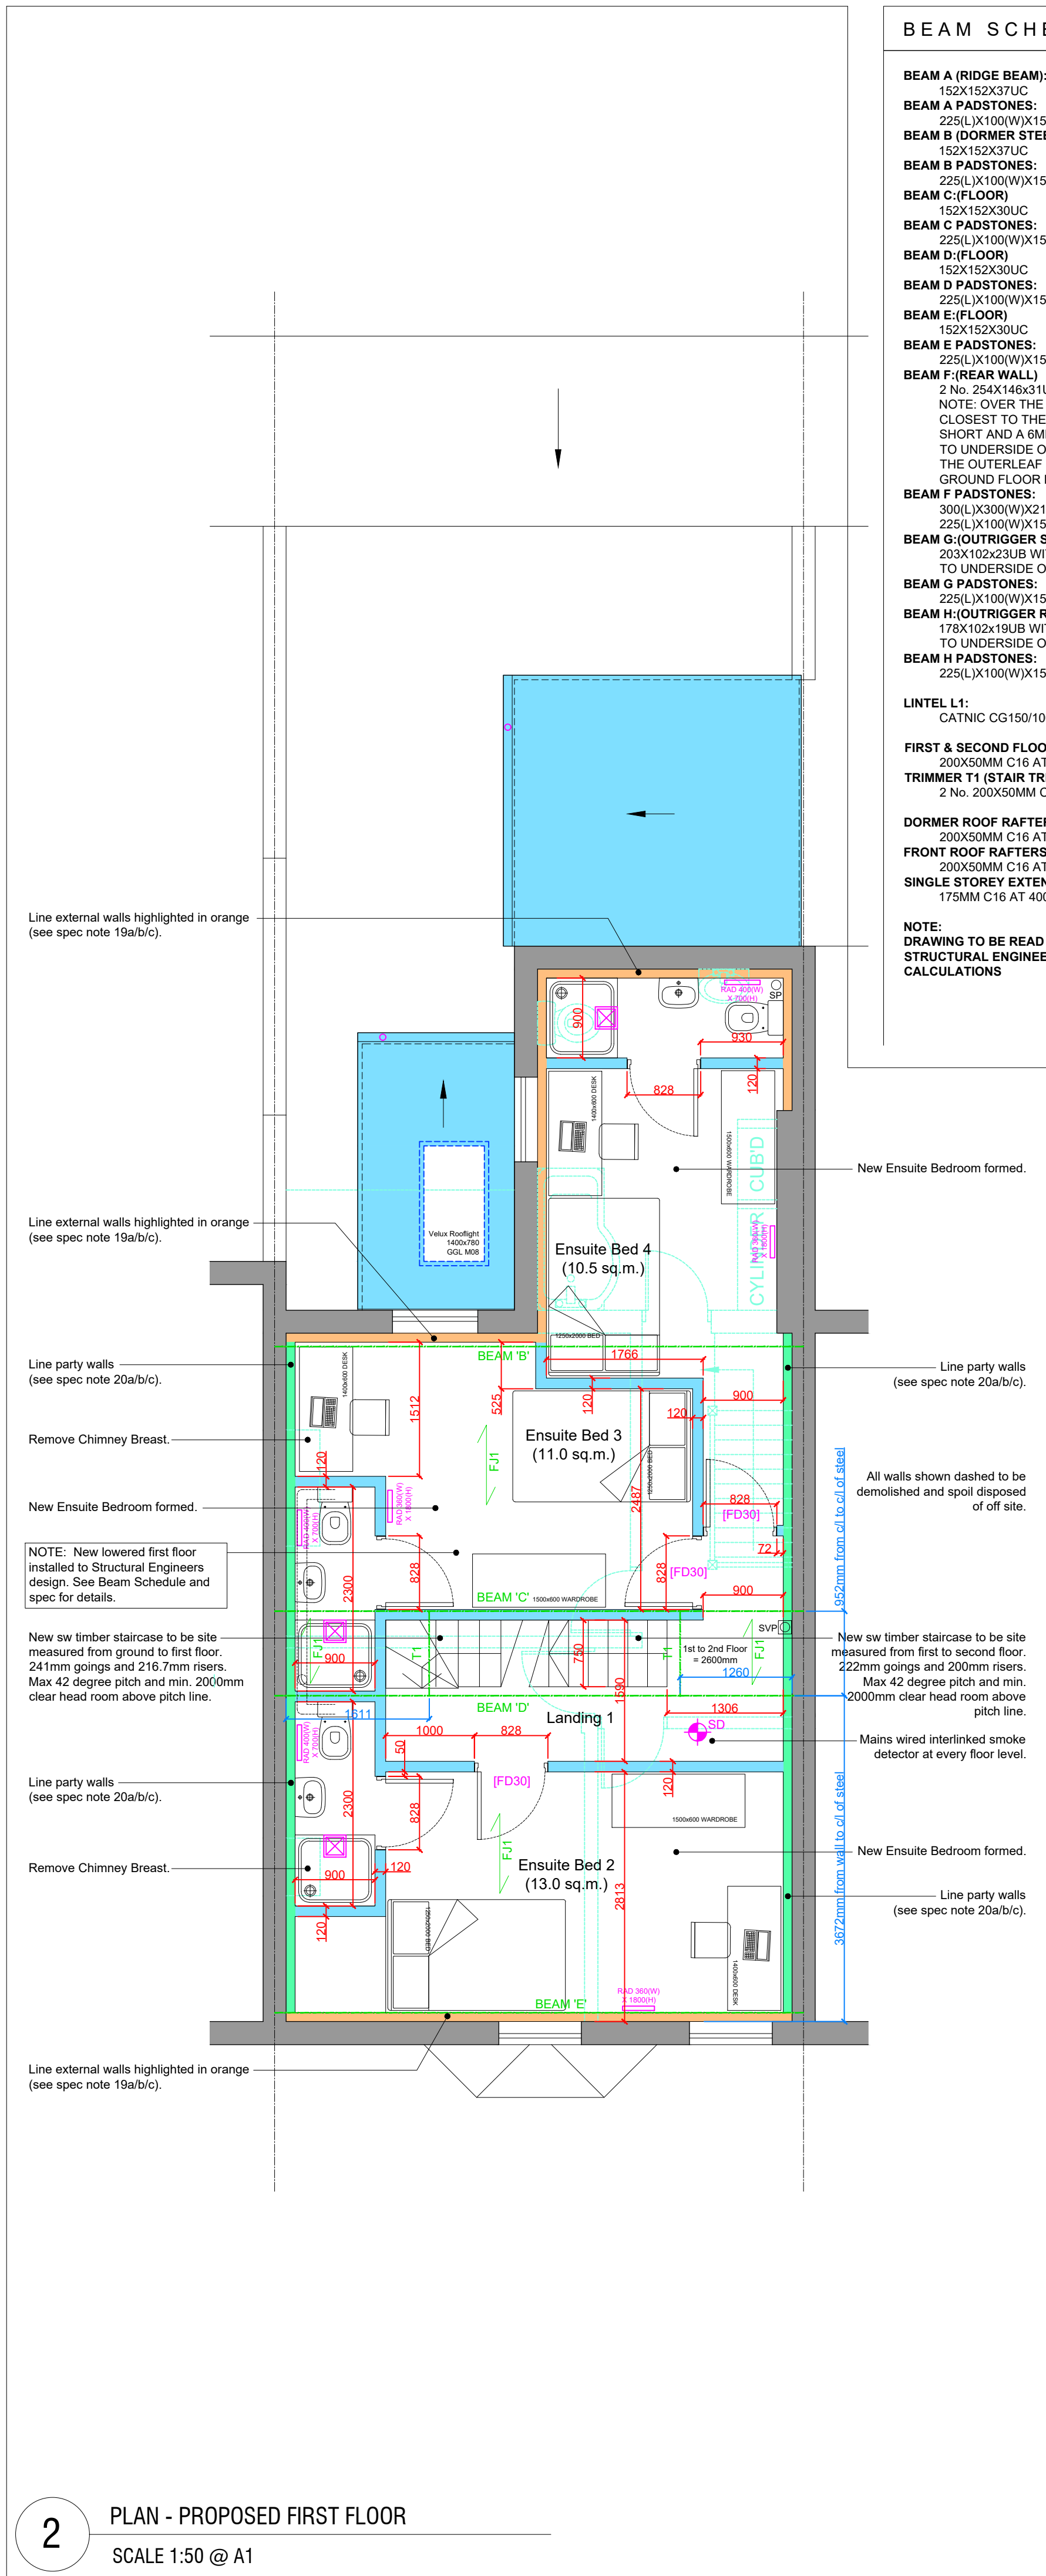


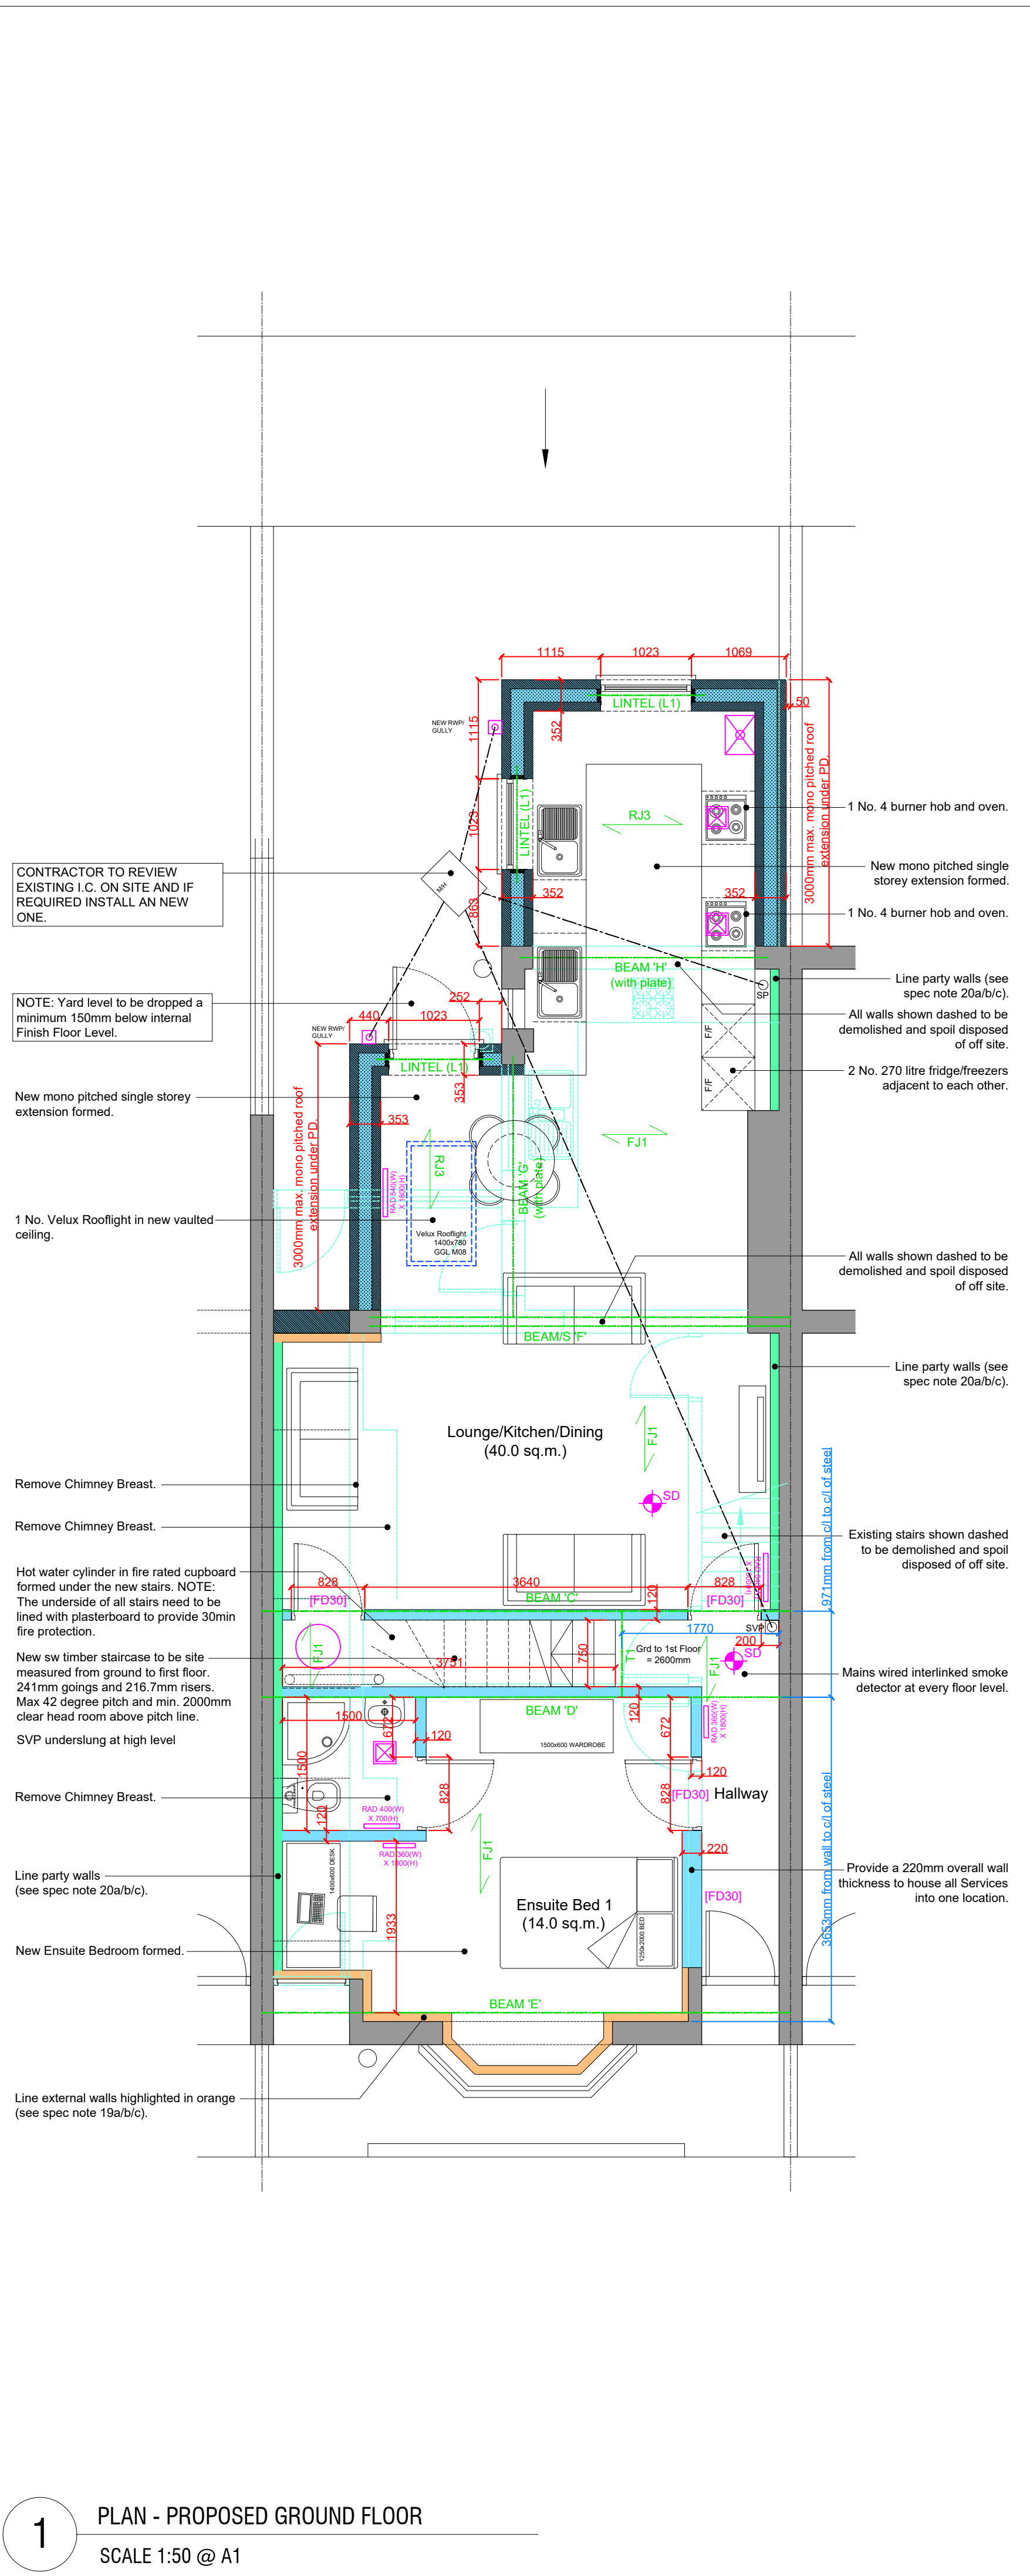

ELECTRICAL LEGEND	
SYMBOL	DESCRIPTION
	Consumer Unit
	Telephone Point
	Television Point
	Double Socket 450mm above ff level
	Double Socket 1050mm above ff level
	Single Socket 450mm above ff level
	Switched Fused Spare 1050mm above ff level
	Light Switch 1200mm above ff level
	Drop Pendant Light Fitting
	Spot Light
	Extract Fan (Bathroom & W.C. to have isolator switch above doorway)
	Comb Boiler
	Thermostat
	Heat Detector
	Smoke Detector interlinked with 8 other and first floor
	External Wall Mounted Light Fitting with PIR
	External Wall Mounted Light Fitting

PLEASE NOTE:

The information is subject to relevant statutory approvals.

© This drawing is copyright of Awake Architects Ltd, and may not be reproduced in any way without their specific permission.
Awake Architects is Limited Liability Company registered in England and Wales (Reg No 6488638) Registered address: 43 Allerton Rd, Woolton Village, Liverpool, Merseyside, England L25 7RE.

B	11/23	Ground floor plan updated to reflect as built on site, based on Client sketch.	SAB
A	03/23	Structural Information updated.	SAB
REV	DATE	DESCRIPTION	BY
OP: OUTLINE			
PL: PLANNING			
BR: BUILDING REGULATIONS			
TI: TENDER			
CI: CONSTRUCTION			
AB: AS BUILT			

CLIENT	Mr T Rehman
---------------	-------------

LOCATION
74 Dixon St, Lincoln, LN5 8AG

PROJECT
HMO Conversion

DRAWING TITLE
Proposed Plans

SCALE @ A1 1:50	DRAWN BY SAB	SCALE BAR @ 1:50 	
JOB REF. SP2097	DRAWING NO. BR03	REV. B	DATE 02/2023